
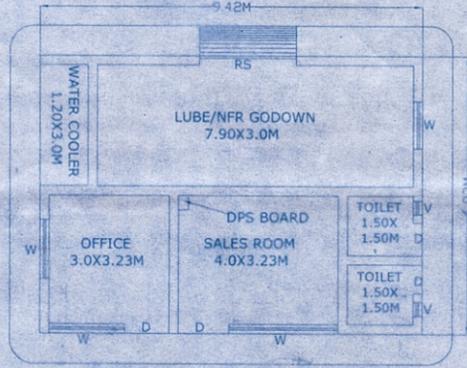


0.23 M THICK & 1.20 M HIGH B.M. BOUNDARY WALL

CROSS SECTION AT 'AB'

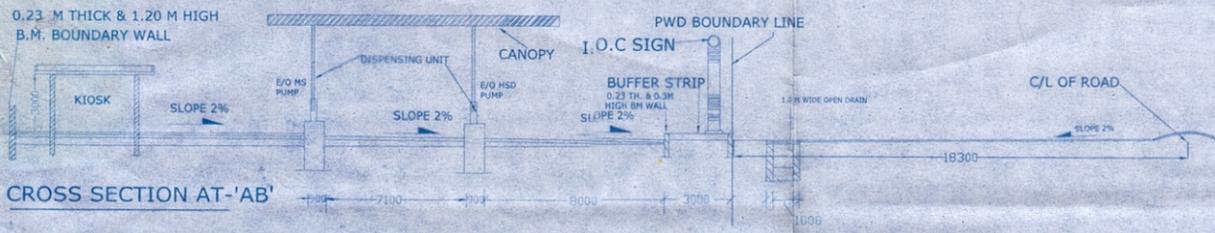

BUILDING PLAN


ITEM	SIZE	PET. CL.	CAP. PROD.
T1	2.10x6.25	CLASS 'A'	20 KL MS
T2	2.10x6.25	CLASS 'B'	20 KL HSD
DU1	4000x900	CLASS 'A'	DUO MS
DU2	4000x900	CLASS 'B'	DUO HSD

ENTR/EXIT
MIDDLE SPACE




NOTES:-

- V- VENT PIPES 4 M HIGH AND 4.0 M CLEAR ALROUND END COVERED WITH 2 LAYERS OF BRASS WIRE GAUGE 11 MESH PER LINEAR CENTIMETER.
- F= FILL POINTS FITTED WITH CAM LOCK COUPLE IN AND AIR TIGHT THREADED BRASS CAP FOR DECANTING FROM TANK LORRY.
- D= DIP PIPES WITH CAP ASSEMBLY.
- ALL ELECTRICAL FITTINGS ARE FLAME PROOF CONFORMING TO IS: 2148.
- ALL DOORS OF BUILDING TO BE OPENED OUTWARDLY.
- NO SEWER OR SURFACE DRAIN WITHIN 6 M OF THE U/G TANKS & D/U.
- PREMISES TO BE USED FOR ONLY STORAGE OF PETROLEUM PRODUCTS.
- TANKS ARE PAINTED WITH TWO LAYERS OF HOT BITUMEN OVER TWO COATS OF RED LEAD PRIMER TO PROTECT AGAINST CORROSION.
- FABRICATION DESIGN OF UNDER GROUND STORAGE TANK ARE CONFORMING TO IS: 10987:1992 AS PER. C.C.O.E. NAGPUR ORDER NO. G-40 (SC)/PMISC. 94 DATED 24.02.99.
- ALL DIMENSIONS ARE IN MM. UNLESS OTHERWISE NOTED.
- S.B.- SAND BUCKET 10 NOS AS PER EXPLOSIVE RULES.
- F.E.- FIRE EXTINGUISHER-10 NOS AS PER EXPLOSIVE RULES.
- TANK GIVEN HYDRAULIC PRESSURE TEST PRIOR TO INSTALLATION AND BEFORE ANY PROTECTIVE COATING AS APPLIED. THE TEST SHOULD BE MENTIONED AT A CONTROLLED PRESSURE OF 0.36 KG/SQ.C.M. FOR 2 HOURS.
- DIP ROD SUPPLIED WITH THE TANK FOR THIS TYPE OF INSTALLATION SHOULD BE 3280 MM LONG INSTEAD OF STANDARD 2350 MM.
- FABRICATION THICKNESS OF SHELL PLATES AND END PLATE OF TANKS:
20 KL SHELL- 6 MM
END - 8 MM
- TANKS CONFORMS TO 124, 125 & 131 OF THE PETROLEUM RULE - 2002.
- ALL LIGHT POLES ARE FITTED AS PER APPROVAL OF C.C., NAGPUR VIDE LETTER NO. PL-111(MB) DATED:26.11.1993.
- NATURAL DOWN SLOPE FROM THE EDGE OF METAL ROAD TO CULVERT ON APPROACHES WILL BE MAINTAINED FREE FLOW OF WATER TOWARDS DRAIN.
- SITE MEETS APPLICABLE IRC 1983 NORMS WITH LATEST AMENDMENTS.
- EV = EXTENDED VENT POINTS
F = EXTENDED FILL POINTS.
- THE PROPOSED SITE IS FREE FROM ANY TYPE OF LITIGATION AND NO CASE IS PENDING IN ANY COURT OF LAW.
- NO ELECTRIC LINE PASSING OVER THE R.O. PREMISES.

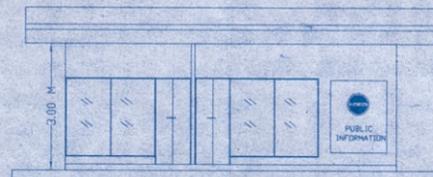

FRONT ELEVATION

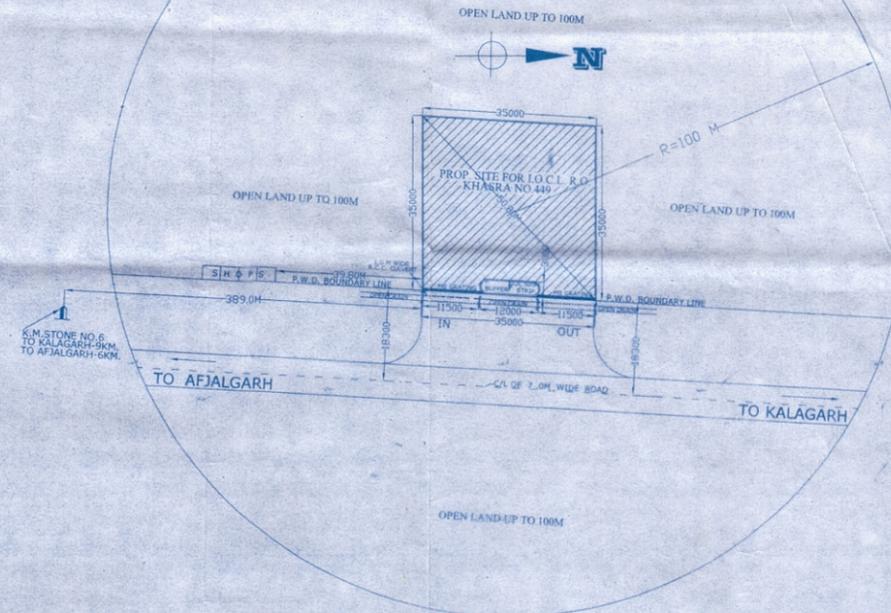

SITE/DRAINAGE PLAN

SCALE-1:800

आवक्य/संस्कार के मानकी आवादाए

- पुस्तावित निर्माण 2 मीटर पर P.W.D. की लाईन आगे की गयी है (दूरी 50 मीटर (पन्ना फीट) सुर्यावित की जाती है। रोड लाईन के अन्तर्गत की चारा 7(2) में विहित प्रावधानों के अन्तर्गत मार्ग के प्रथम से बंधू द्रोण एवं 60 मीटर (60 फीट) करना होगा।
- आवक्य को पुस्तावित स्थल के आगे गले पर आवागमन हेतु पुलिया निर्माण को अपने व्यय से करना होगा एवं जिनका मानक प्लान विभाग से स्वीकृत कराकर आवेदक को करना होगा।
- आवेदक को पुस्तावित निर्माण की कुर्से मार्ग की लेपित साह से नीचे रखनी होगी।
- श्र-स्वाश्रित से सम्बन्धित केमका उत्तरदायी नहीं होगा।
- अनुमोदित प्लान के अनुसार निर्माण कार्य न कराने अथवा किसी भी शर्त का उल्लंघन होने की दशा में पुस्तावित अथवा स्वतः ही निरस्त हो जायेगी।
- पुस्तावित निर्माण के सामने आवेदक को अपनी शक्ति में अपने व्यय से गली का निर्माण अपने व्यय से करना होगा।
- पुस्तावित रोड के फ्लो पेड्रिल फर्म की ड्यूटी 2.00 किमी 0 से अर्ध 6 डूरी पर है तथा मार्ग की चौड़ाई अन्य प्लान मार्ग है।


Site Plan Verified 18.30 M. centre line of the Road as per check list and norms. at site.

सहायक अभियन्ता
निर्माण 2-2 लो. निं. विं.
बिजनोंर - नजीबाबाद
B12NOR (H.O. Nalibabad)


अधीक्षक अभियन्ता
रामपुर वृत्त, लो. निं. विं.
रामपुर

Executive Engineer
Const. Division - 2, P.W.D.
B12NOR (H.O. Nalibabad)

अधीक्षक अभियन्ता
रामपुर वृत्त, लो. निं. विं.
रामपुर

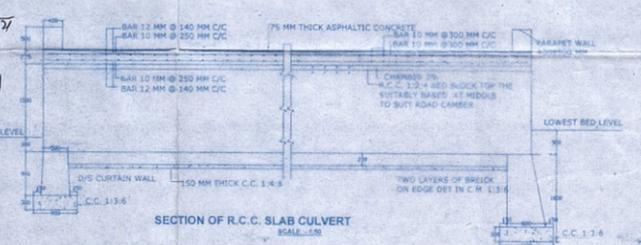


SECTION OF R.C.C. SLAB CULVERT

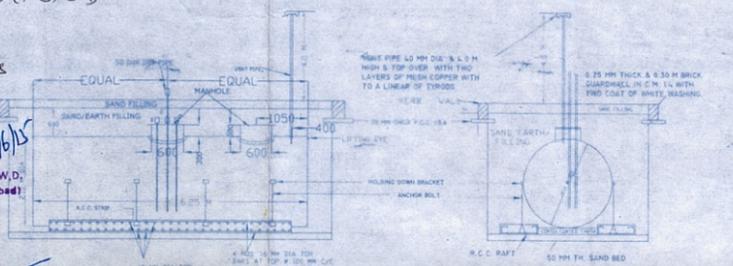

LONGITUDINAL SECTION OF TANK

TYPICAL SECTION OF U/G TANK

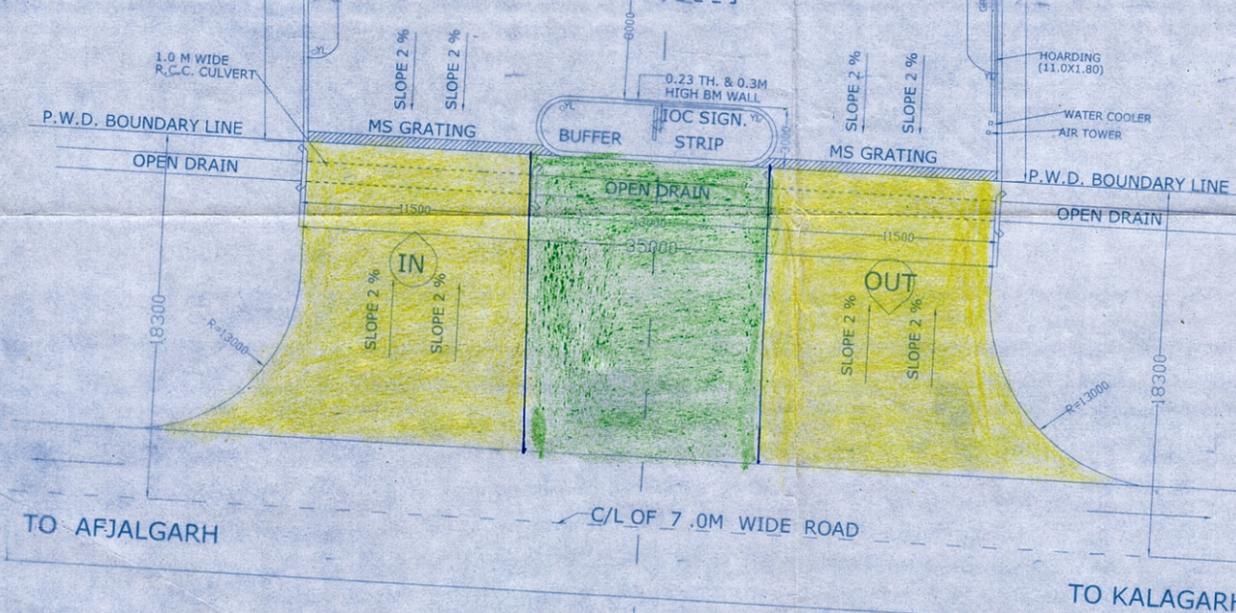

LAYOUT PLAN SCALE:1:200

LOI NO.&DATE:-	NAME OF LOCATION-AZIMULLA NAGAR
LOI HOLDER:-	TYPE OF RO-NEW 'A' SITE KSK LICENCE NO.
KHASRA NO. 449	INDIAN OIL CORPORATION LTD. (MARKETING DIVISION) (NORTHERN REGION)
VILLAGE AZIMULLA NAGAR	MORADABAD DIVISIONAL OFFICE
ROAD VILL ROAD	PROPOSED LAYOUT & SITE PLAN FOR RETAIL
TEHSIL DHAMPUR	OUTLET ON AFJALGARH - KALAGARH ROAD
DISTT. BIJNOR	AT-KHASRA NO. 449
STATE U.P.	AT-VILL-AZIMULLA NAGAR,TEH- DHAMPUR
POLICE STATION AFJALGARH	DISTT. -BIJNOR (U.P.)
RAILWAY STATION DHAMPUR	DATE 25.05.2015
PIN CODE NO. 246722	IOCM/BD/RG/RO/2015
	DATE DRAWING NO.
	PREPARED BY - RAM GOPAL SHARMA
	52 VISHWANATH PURAM COLONY, BADAUN ROAD, BAREILLY
	98370-28296,(0581)2435188

R E V I S I O N S