



TOTAL FOREST LAND AREA
 ENTRY SIDE- ABCD-225.6029SQM
 MIDDLE AREA-CDEF-268.7943SQM
 EXIT SIDE-EFGH-225.6029SQM
 TOTAL FOREST LAND AREA-720.000SQM
 HFC-0.072

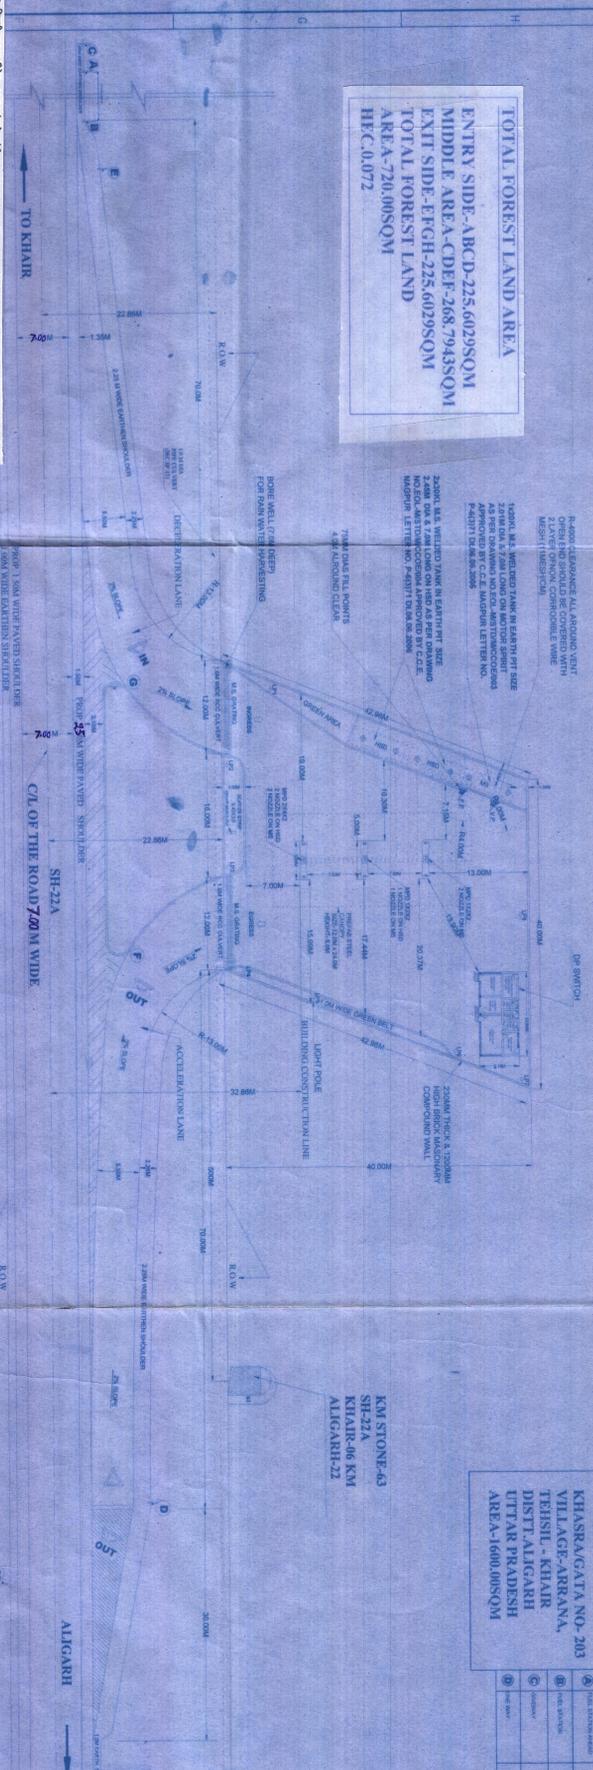

LAND DETAIL
 KHASRAGATA NO-203
 VILLAGE-ARRANA,
 TEHSIL - KHAIR
 DISTT-ALIGARH
 UTTAR PRADESH
 AREA-1600.000SQM

SYMBOL	DESCRIPTION
⊠	ROAD SIGNAGE
⊡	WATER TOWER
⊢	WATER TOWER
⊣	WATER TOWER
⊤	WATER TOWER
⊥	WATER TOWER
⊦	WATER TOWER
⊧	WATER TOWER
⊨	WATER TOWER
⊩	WATER TOWER
⊪	WATER TOWER
⊫	WATER TOWER
⊬	WATER TOWER
⊭	WATER TOWER
⊮	WATER TOWER
⊯	WATER TOWER
⊰	WATER TOWER
⊱	WATER TOWER
⊲	WATER TOWER
⊳	WATER TOWER
⊴	WATER TOWER
⊵	WATER TOWER
⊶	WATER TOWER
⊷	WATER TOWER
⊸	WATER TOWER
⊹	WATER TOWER
⊺	WATER TOWER
⊻	WATER TOWER
⊼	WATER TOWER
⊽	WATER TOWER
⊾	WATER TOWER
⊿	WATER TOWER


LAYOUT PLAN
 SCALE-1:100

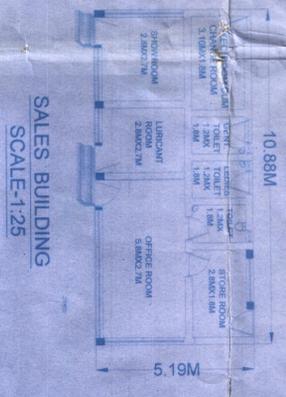


SALES BUILDING
 SCALE-1:25



DETAIL SECTION OF APPROACH ROAD

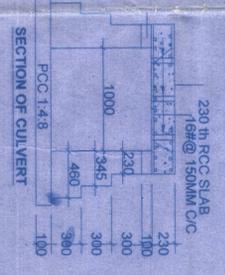









SECTION OF 230 TH RCC SLAB
 168@150MM C/C
 PCC 1:4:8

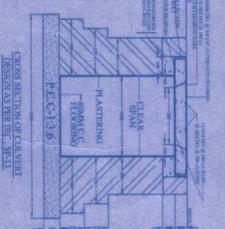

DETAIL OF R.C.C SLAB CULVERT
 SCALE :- NTS

1. ...
 2. ...
 3. ...
 4. ...
 5. ...
 6. ...
 7. ...
 8. ...
 9. ...
 10. ...
 11. ...
 12. ...

DETAIL SECTION OF DRIVE WAY

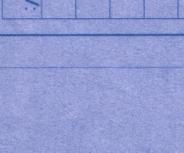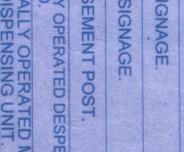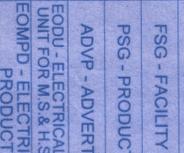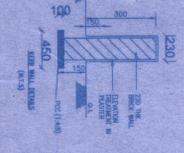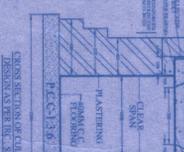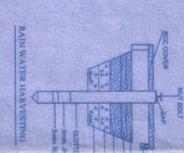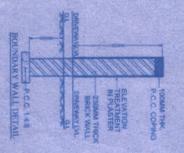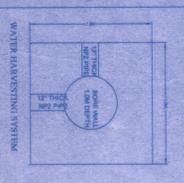

SITE PLAN
 SCALE-1:200

REFERENCES

- S - SUCTION PIPE 50 NB.
- V - VENT PIPE 40 NB.
- F - FILL PIPE 80 NB.
- D - DIP PIPE 50 NB.
- EV - EXTENDED VENT.
- EFP - EXTENDED FILL PIPE.
- ILLUMINATION POST.
- VALVE ON U.G. PIPE LINE.
- DPS - DOUBLE POLE SWITCH.
- FSG - FACILITY SIGNAGE.
- PSG - PRODUCT SIGNAGE.
- ADVP - ADVERTISEMENT POST.
- EODU - ELECTRICALLY OPERATED DISPENSING UNIT FOR M.S. & H.S.D.
- COMPD - ELECTRICALLY OPERATED MULTY PRODUCT DISPENSING UNIT.

REV.	DESCRIPTION	DATE	DRAWN	CHKD.	APPD.
1	AS-BUILT				
0	FOR SUBMISSION				

APPROVAL STAMP

ESSAR OIL LIMITED

FUELING STATION-LAYOUT PLAN OF A ESSAR OIL LTD. AT SH-22A, ALIGARH -KHAIR ROAD, CHAINAGE NO-62.500 KHASRA NO- 203 - VILLAGE- ARRANA, TEHSIL- KHAIR, -DIST-ALIGARH, UTTAR PRADESH

DRAWN BY :	AS SHOWN	DATE :	01-12-2014
CHKD. BY :		DATE :	
APPD BY :		DATE :	
SCALE :	AS SHOWN		
DRG NO. :	EOL-W-1519		
REV. :	A		